


# environmental impact statement supplementary report

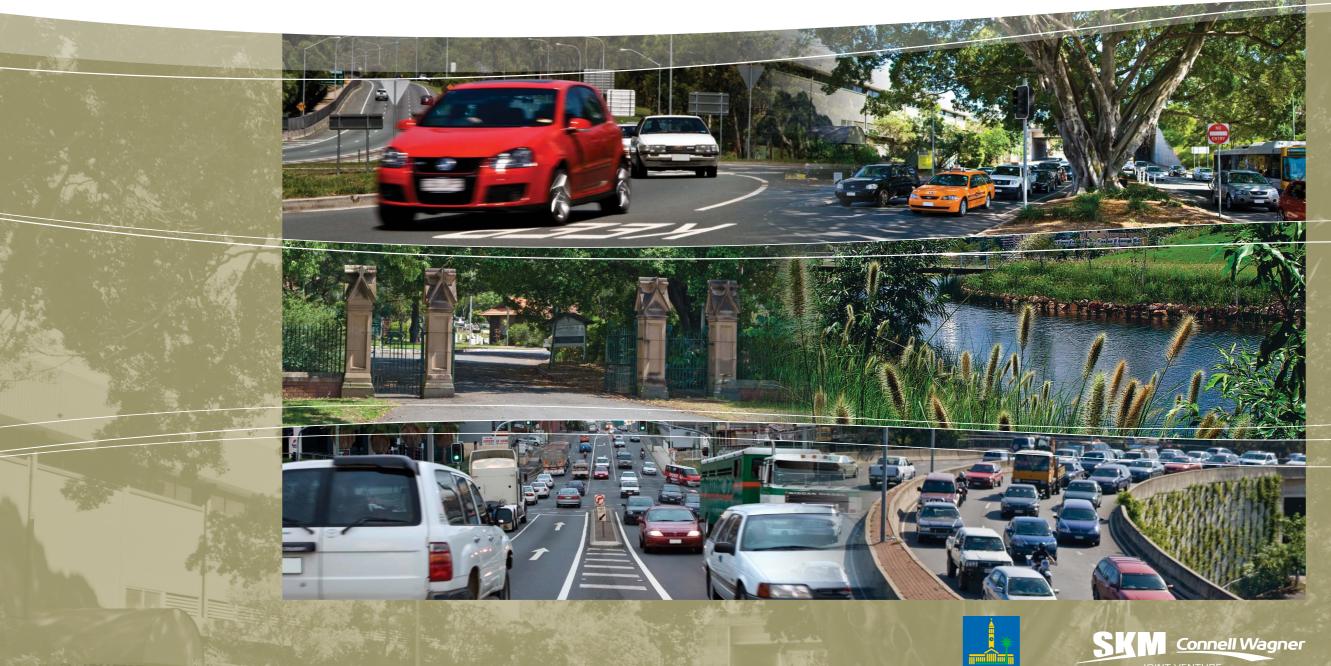



# SUPPLEMENTARY REPORT NORTHERN LINK PROJECT DESIGN

#### DRAWING INDEX

#### PLANNING LAYOUTS

DRAWING No.	DESCRIPTION
EIS-PL-00	PLANNING LAYOUTS - KEY SHEET LAYOUT
EIS-PL-01	PLANNING LAYOUTS - (PLAN 1 OF 10)
EIS-PL-02	PLANNING LAYOUTS - (PLAN 2 OF 10)
EIS-PL-03	PLANNING LAYOUTS - (PLAN 3 OF 10)
EIS-PL-04	PLANNING LAYOUTS - (PLAN 4 OF 10)
EIS-PL-05	PLANNING LAYOUTS - (PLAN 5 OF 10)
EIS-PL-06	PLANNING LAYOUTS - (PLAN 6 OF 10)
EIS-PL-07	PLANNING LAYOUTS - (PLAN 7 OF 10)
EIS-PL-08	PLANNING LAYOUTS - (PLAN 8 OF 10)
EIS-PL-09	PLANNING LAYOUTS - (PLAN 9 OF 10)
EIS-PL-10	PLANNING LAYOUTS - (PLAN 10 OF 10)

## TYPICAL CROSS SECTIONS

DRAWING N	lo. DESCRIPTION	
EIS-TX-01 EIS-TX-02 EIS-TX-03 EIS-TX-04	TYPICAL CROSS SECTION DETAILS - TWO LANE TUNNEL BORING MACHINE (TBM) TYPICAL CROSS SECTION DETAILS - TWO LANE TUNNEL BORING MACHINE (TBM) CROSS PASSAGE TYPICAL CROSS SECTION DETAILS - TWO LANE TUNNEL BORING MACHINE (TBM) CROSS PASSAGE SECTION TYPICAL CROSS SECTION DETAILS - TWO LANE CUT AND COVER TUNNEL WITH VENTILATION TUNNEL	

# LONGITUDINAL SECTIONS

DRAWING No.	DESCRIPTION
EIS-LS-01 EIS-LS-02 EIS-LS-03 EIS-LS-04	LONGITUDINAL SECTIONS - NORTHERN LINK TUNNEL EASTBOUND - (SHEET 1 OF 2) LONGITUDINAL SECTIONS - NORTHERN LINK TUNNEL EASTBOUND - (SHEET 2 OF 2) LONGITUDINAL SECTIONS - NORTHERN LINK TUNNEL WESTBOUND - (SHEET 1 OF 2) LONGITUDINAL SECTIONS - NORTHERN LINK TUNNEL WESTBOUND - (SHEET 2 OF 2)

## CONSTRUCTION SITE PLANS

DRAWING No.	DESCRIPTION
EIS-CS-00 EIS-CS-01 EIS-CS-02	PROPOSED CONSTRUCTION SITE - KEY SHEETS LAYOUT INDICATIVE WESTERN FREEWAY CONSTRUCTION SITE PROPOSED WESTERN FREEWAY CONNECTION - INDICATIVE CONVEYOR LOCATION

## TRAFFIC MANAGEMENT AND STAGING

DRAWING No.	DESCRIPTION
EIS-TM-00	TRAFFIC MANAGEMENT AND STAGING - KEY SHEETS LAYOUT
EIS-TM-01	TRAFFIC MANAGEMENT AND STAGING - WESTERN FREEWAY CONNECTION - (PLAN 1 OF 4)
EIS-TM-02	TRAFFIC MANAGEMENT AND STAGING - WESTERN FREEWAY CONNECTION - (PLAN 2 OF 4)
EIS-TM-03	TRAFFIC MANAGEMENT AND STAGING - WESTERN FREEWAY CONNECTION - (PLAN 3 OF 4)
EIS-TM-04	TRAFFIC MANAGEMENT AND STAGING - WESTERN FREEWAY CONNECTION - (PLAN 4 OF 4)
EIS-TM-05	TRAFFIC MANAGEMENT AND STAGING - INNER CITY BYPASS CONNECTION - (PLAN 1 OF 4)
EIS-TM-06	TRAFFIC MANAGEMENT AND STAGING - INNER CITY BYPASS CONNECTION - (PLAN 2 OF 4)
EIS-TM-07	TRAFFIC MANAGEMENT AND STAGING - INNER CITY BYPASS CONNECTION - (PLAN 3 OF 4)
EIS-TM-08	TRAFFIC MANAGEMENT AND STAGING - INNER CITY BYPASS CONNECTION - (PLAN 4 OF 4)
EIS-TM-06 EIS-TM-07	TRAFFIC MANAGEMENT AND STAGING - INNER CITY BYPASS CONNECTION - (PLAN 2 OF 4) TRAFFIC MANAGEMENT AND STAGING - INNER CITY BYPASS CONNECTION - (PLAN 3 OF 4)

## **VENTILATION SITE PLANS**

DRAWING No.	DESCRIPTION
EIS-VS-00 EIS-VS-01 EIS-VS-02	VENTILATION PLAN - KEY SHEETS LAYOUT PROPOSED VENTILATION SITES - WESTERN FREEWAY CONNECTION - (PLAN 1 OF 2) PROPOSED VENTILATION SITES - INNER CITY BYPASS CONNECTION - (PLAN 2 OF 2)

#### **ESTIMATED TUNNEL SETTLEMENT CONTOURS**

DRAWING No.	DESCRIPTION
EIS-SC-00	ESTIMATED TUNNEL SETTLEMENT CONTOURS - KEY SHEET LAYOUT
EIS-SC-01	ESTIMATED TUNNEL SETTLEMENT CONTOURS - (PLAN 1 OF 6)
EIS-SC-02	ESTIMATED TUNNEL SETTLEMENT CONTOURS - (PLAN 2 OF 6)
EIS-SC-03	ESTIMATED TUNNEL SETTLEMENT CONTOURS - (PLAN 3 OF 6)
EIS-SC-04	ESTIMATED TUNNEL SETTLEMENT CONTOURS - (PLAN 4 OF 6)
EIS-SC-05	ESTIMATED TUNNEL SETTLEMENT CONTOURS - (PLAN 5 OF 6)
EIS-SC-06	ESTIMATED TUNNEL SETTLEMENT CONTOURS - (PLAN 6 OF 6)

**PRELIMINARY** 

PROJECT DESIGN Northern Link **Drawing Index** 

NOT FOR CONSTRUCTION 24531 Scale N.T.S. Sketch No. EIS-IND-01

B May 09 Removal of Toowong and Kelvin Grove Connections A Sept 08 EIS Reference Project Design Date Revision Details



